


ı	PART	NO

#### PSG01093


REVISIONS						·	·	·
ECN #	REV	DESCRIPTION	DRAWN	DATE	CHECKD	DATE	APPRVD	DATE
-	Α	RELEASED	Ramya	08/09/09	Pradeep	08/09/09	Farnell	22/09/09

## **Production Outlines (Moulded HDMI 19 Pin Plug to Plug)**

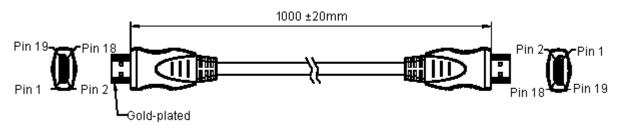

Dimensions : Millimetres

# **Structure of Cable (28AWG Cable)**

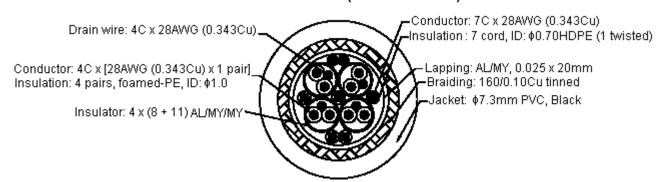

Dimensions: Millimetres

This data sheet and its contents (the "Information") belong to the Premier Farnell Group (the "Group") or are licensed to it. No licence is granted for the use of it other than for information purposes in connection with the products to which it relates. No licence of any intellectual property rights is granted. The Information is subject to change without notice and replaces all data sheets previously supplied. The Information supplied is believed to be accurate but the Group assumes no responsibility for its accuracy or completeness, any error in or omission from it or for any use made of it. Users of this data sheet should check for themselves the Information and the suitability of the products for their purpose and not make any assumptions based on information included or omitted. Liability for loss or damage resulting from any reliance on the Information or use of it (including liability resulting from negligence or where the Group was aware of the possibility of such loss or damage arising) is excluded. This will not operate to limit or restrict the Group is liability for death or personal injuny resulting from its negligence. SPC pro-SIGNAL is the registered trademark of the Group. © Premier Farnell pic 2009.

UNLESS OTHERWISE	
SPECIFIED.	
DIMENSIONS ARE FOR REFERENCE	
FOR REFERENCE	
PURPOSES ONLY.	

**TOLERANCES:** 

DRAWN BY:	DATE:
Ramya	08/09/09
CHECKED BY:	DATE:
Pradeep	08/09/09
APPROVED BY:	DATE:
Farnell	22/09/09

	DRAW	NG TITLE:						
	HDMI Lead - 1m, Plug - Plug							
	SIZE	DWG NO.		ELECTRONIC FILE				REV
-	Α			1734852_DWG				Α
SCALE: NTS			U.O.M.: mm		SHEET:	1	OF	2



PA	RT	NO

PSG01093

		REVISIONS						
ECN #	REV	DESCRIPTION	DRAWN	DATE	CHECKD	DATE	APPRVD	DATE
-	Α	RELEASED	Ramya	08/09/09	Pradeep	08/09/09	Farnell	22/09/09

# **Wiring Diagram**

Type A PIN		Signal Assignmer	nt	Type A PIN
1 red —— 2 earth —— 3 white ——	$\equiv$	$>\!\!\!>$	$\bigoplus$	red 1 earth 2 white 3
4 blue ——— 5 earth ——— 6 white ———	$\equiv$	$>\!\!\!>$	E	blue 4 earth 5 white 6
7 green —— 8 earth —— 9 white ——	$\equiv$	>>>	Œ	green 7 earth 8 white 9
10 brown 11 earth 12 white	$\equiv$	$>\!\!\!>$	E	brown 10 earth 11 white 12
13	green	CEC	green	13
14	grey		grey	14
15	orange	SCL	_orange	15
16	purple	SDA	purple	16
17	white	DDC/CEC Ground	_white	17
18	red	+5 Volts Power	_red	18
19	yellow	Hot Plug Detect	_yellow	19

### **Part Number Table**

Description	Part Number
Lead, HDMI, 1m	PSG01093

http://www.farnell.com

http://www.newark.com

http://www.cpc.co.uk

This data sheet and its contents (the "Information") belong to the Premier Farnell Group (the "Group") or are licensed to it. No licence is granted for the use of it other than for information purposes in connection with the products to which it relates. No licence of any intellectual property rights is granted. The Information is subject to change without notice and replaces all data sheets previously supplied. The Information supplied is believed to be accurate but the Group assumes no responsibility for its accuracy or completeness, any error in or omission from it or for any use made of it. Users of this Change with the Change of the data sheet should check for themselves the Information and the suitability of the products for their purpose and not make any assumptions based on information included or omitted. Liability for loss or damage resulting from any reliance on the Information included or omitted. Liability for loss or damage resulting from any reliance on the Information or use of it (including liability resulting from negligence or where the Group was aware of the possibility of such loss or damage arising) is excluded. This will not operate to limit or restrict the Group's liability for death or personal injury resulting from its negligence. SPC pro-SIGNAL is the registered trademark of the Group. © Premier Farnell plc 2009.

UNLESS OTHERWISE
SPECIFIED, DIMENSIONS ARE FOR REFERENCE
DIMENSIONS ARE
FOR REFERENCE
PURPOSES ONLY.

DRAWN BY:	DATE:
Ramya	08/09/09
CHECKED BY:	DATE:
Pradeep	08/09/09
APPROVED BY:	DATE:
Farnell	22/09/09

	DRAW	NG TITLE:						
			HDMI Lead - 1m,	Plug	- Plug			
	SIZE	DWG NO.		ELEC	TRONIC FIL	_E		REV
_	Α		1734852_DWG				Α	
	SCAL	E: NTS	U.O.M.: mm		SHEET:	2	OF	- 2